

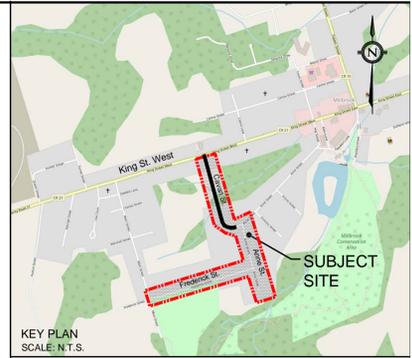


REFER TO DWG. P-2  
MATCH LINE STA. 0+325.00

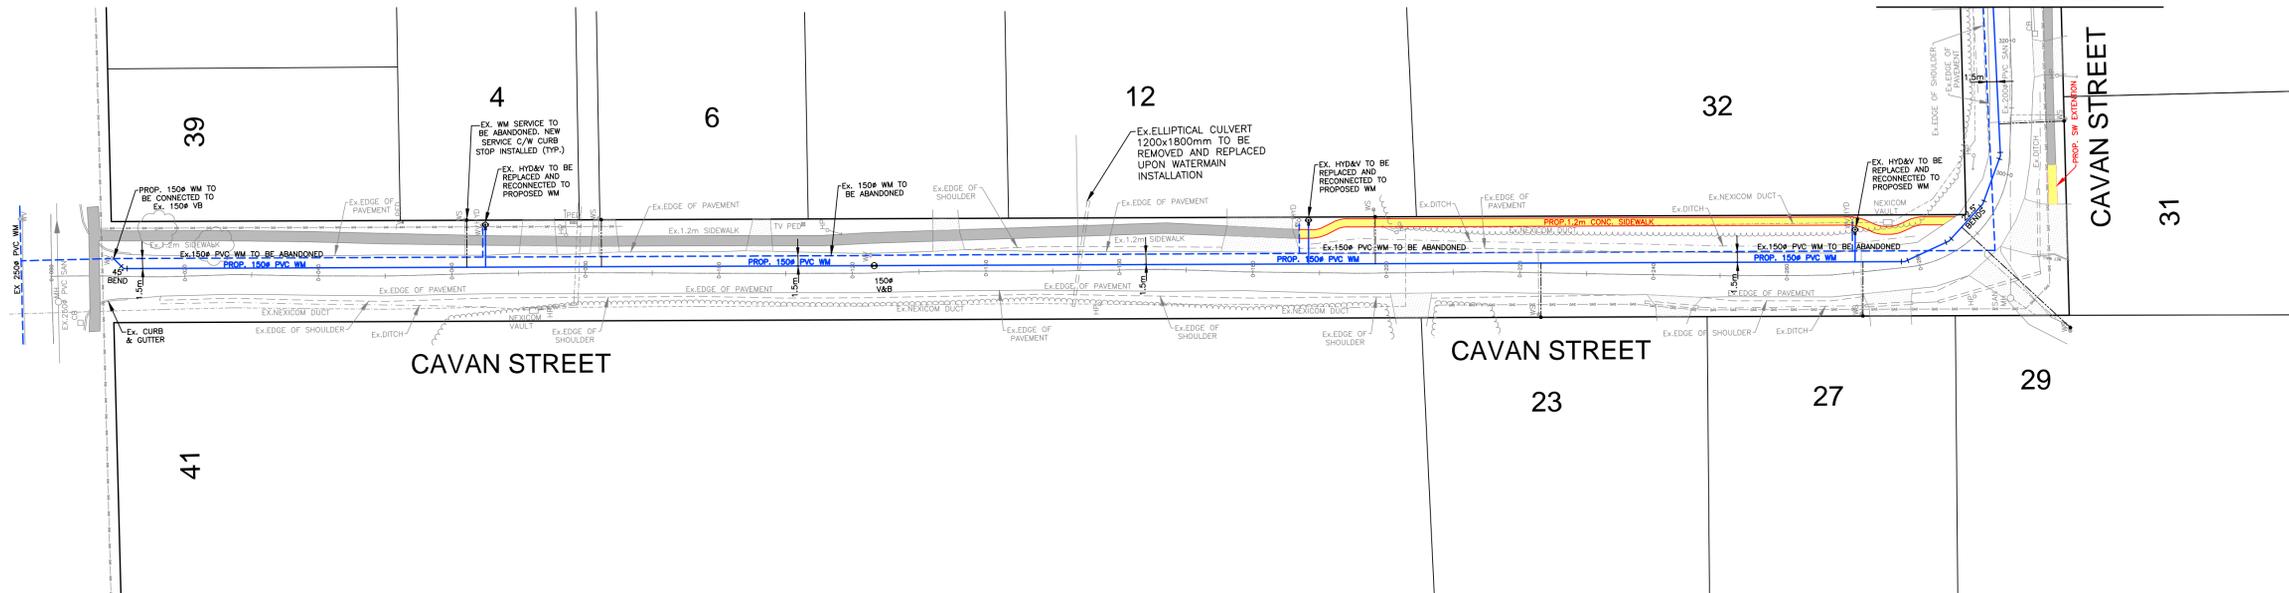

KEY PLAN  
SCALE: N.T.S.

- LEGEND**
- SUBDIVISION BOUNDARY
  - SANITARY MAINTENANCE HOLE
  - STORM MAINTENANCE HOLE
  - WATER SERVICE CONNECTION
  - SINGLE SANITARY/STORM SERVICE CONNECTION
  - SINGLE CATCHBASIN
  - DOUBLE CATCHBASIN
  - V&C VALVE AND BOX
  - H&V HYDRANT & VALVE
  - UTILITY CROSSINGS
  - COMMUNITY MAILBOX
  - S.L. STREET LIGHT
  - ▲ HYDRO TRANSFORMER
  - ▲ STOP SIGN
  - ▲ STREET NAME SIGN
  - ▲ NO EXIT SIGN
  - SWITCHGEAR
  - STREETLIGHT SERVICE PEDESTAL
  - NEXICOM CABLE VAULT FLUSH TO GRADE
  - ENBRIDGE GAS DISTRICT STATION
  - GAS
  - Ex. GASMAIN
  - CA Ex. NEXICOM CABLES

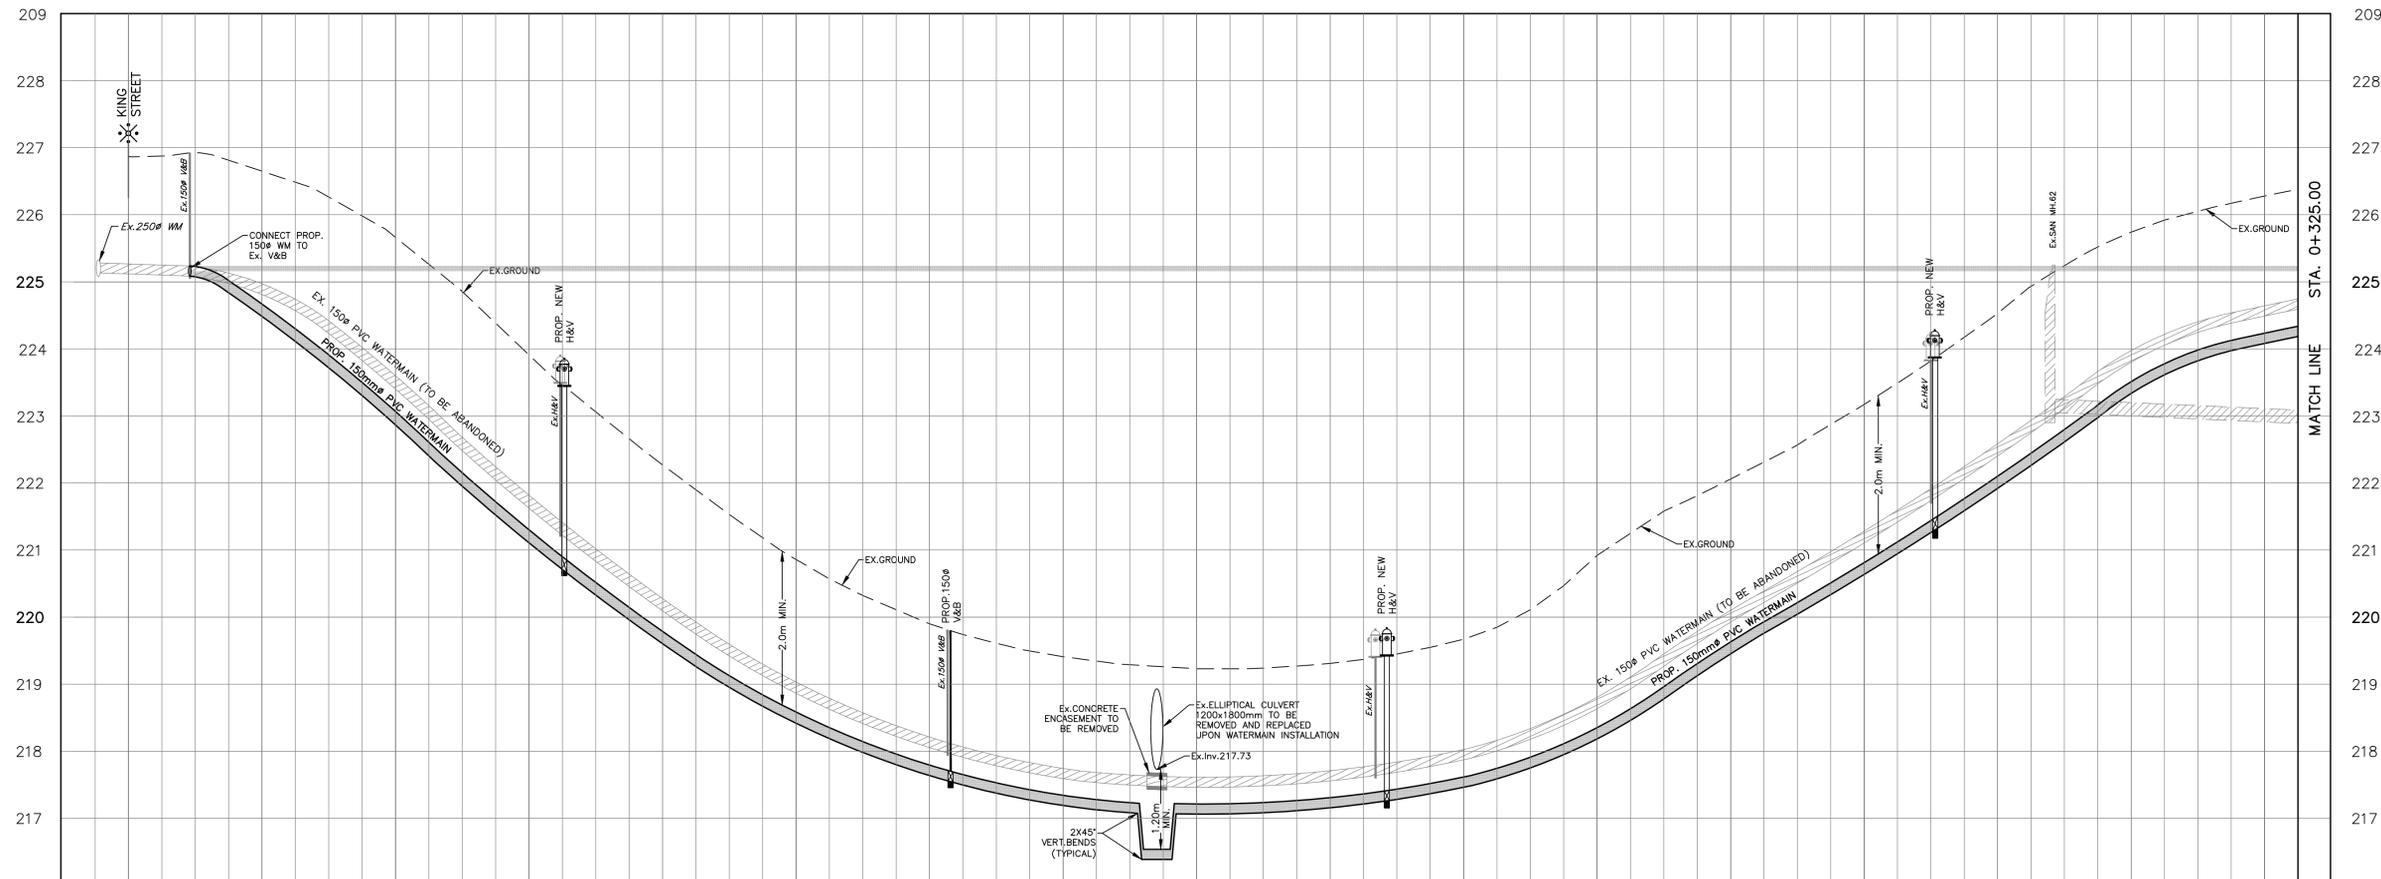

CL CHAINAGE	0+000	0+020	0+040	0+060	0+080	0+100	0+120	0+140	0+160	0+180	0+200	0+220	0+240	0+260	0+280	0+300	0+320	STORM SEWER INVERT
EXISTING & PROPOSED CL ELEVATION	226.87	226.65	226.66	223.91	222.27	220.86	219.90	218.41	218.23	219.31	218.67	220.92	222.06	223.17	224.53	225.74	226.28	STORM SEWER INVERT
SANITARY SEWER INVERT																		SANITARY SEWER INVERT
CL CHAINAGE	0+000	0+020	0+040	0+060	0+080	0+100	0+120	0+140	0+160	0+180	0+200	0+220	0+240	0+260	0+280	0+300	0+320	CL CHAINAGE

No.	Revision	Date	By	App'd

CONSULTANT:

SIGNATURE AS TO FORM IN RELIANCE UPON THE PROFESSIONAL SKILL AND ABILITY OF THE CONSULTING ENGINEERS AS TO DESIGN AND SPECIFICATIONS.

DIRECTOR OF PUBLIC WORKS  
W. HANCOCK, P.ENG.

SIGNATURE \_\_\_\_\_ DATE \_\_\_\_\_

**2026 WATERMAIN REPLACEMENT PROGRAM**

**VALDOR ENGINEERING INC.**  
Consulting Engineers - Project Managers  
371 Chelsea Road, Unit 4, 2nd Floor, Woodbridge, Ontario, L4L 8K2  
TEL: (905)264-0054, FAX: (905)264-0069, E-MAIL: info@valdor-engineering.com  
www.valdor-engineering.com

FORWARDED BY  
**COUNTY OF PETERBOROUGH**

PLAN AND PROFILE  
**CAVAN & ANNE STREETS  
WATERMAIN REPLACEMENT**  
FROM STA. 0+00000 TO STA. 0+325.00

Surveyed by: V.L.	Checked by: P.S.Z.	Project No. <b>25129</b>
Drawn by: V.L.	Approved by: D.G.	Drawing No. <b>PP-3</b>
Scale: Horz. 1:500 Vert. 1:50		Sheet No. _____

N:\Projects\2025\25129\25129.dwg, P:\3, 2025.02.20 11:18 PM, vldor